


ROLLER SHADES

- 3% SHADE FABRIC
- COLOR - Charcoal
- VALANCES - at all locations except classrooms with wood ceilings.
- HEIGHTS - as noted on RCPs
- WIDTHS - as indicated by red boxes on RCPs. Dashed red lines indicate extent of individual shades within a single run. Dashed lines align w/ centerlines of mullions unless otherwise noted.

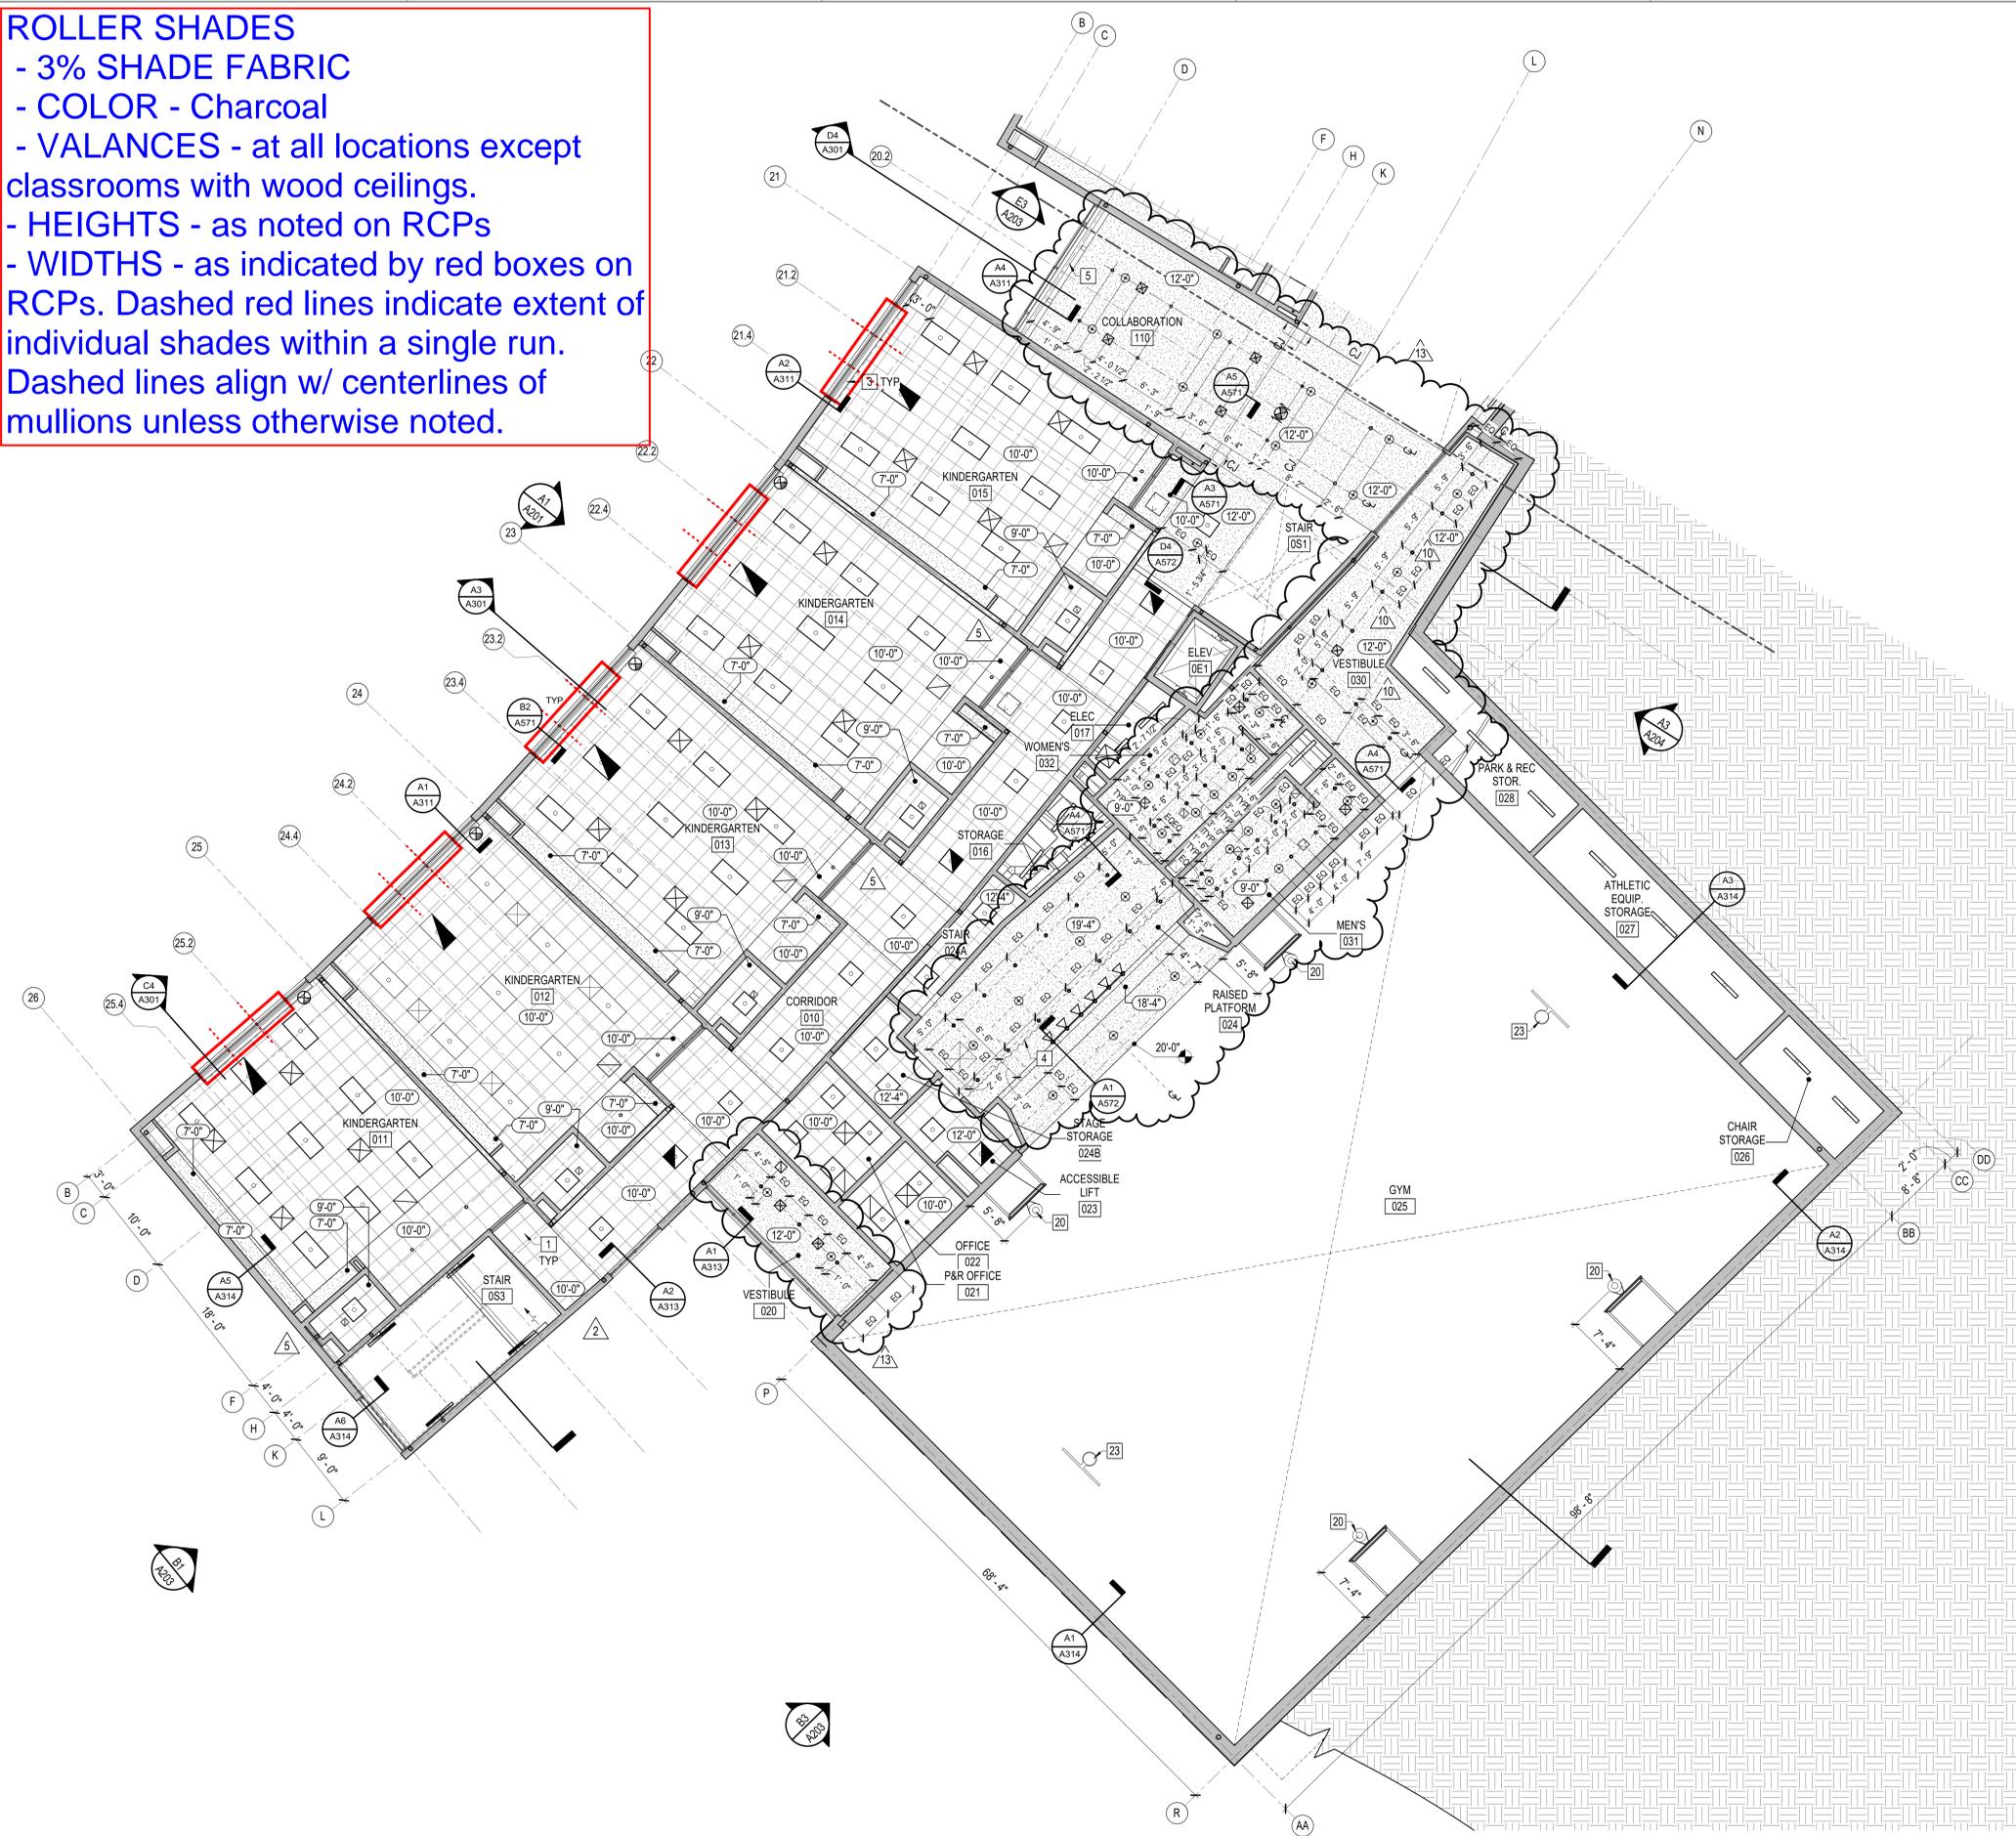


GENERAL NOTES

1. REFER TO SHEET A-001 FOR RCP LEGEND.
2. REFER TO SHEETS A571 - A572 FOR CEILING DETAILS.
3. ALL CEILINGS ARE 10'-0" AFF, UON.
4. HVAC & LIGHTING FIXTURES SHOWN ARE FOR GRAPHICAL PURPOSES ONLY. GC TO REFER TO PME DRAWINGS AND SPRINKLER PIPING SHOP DRAWINGS AND SHOULD NOTIFY ARCHITECT IMMEDIATELY OF ANY CONFLICTS OR DISCREPANCIES.
5. GENERAL CONTRACTOR TO COORDINATE ALL SOFFIT/BULKHEAD FRAMING WITH FINAL LIGHTING FIXTURES & HVAC DIFFUSER LOCATIONS.
6. GENERAL CONTRACTOR TO FIELD VERIFY CEILING HEIGHTS SHOWN ON RCP DRAWINGS PRIOR TO INSTALLATION OF ALL MECHANICAL DUCTWORK, SPRINKLER PIPING, ELECTRICAL EQUIPMENT, CONDUITS, ETC. ARCHITECT TO BE NOTIFIED IMMEDIATELY OF ANY DISCREPANCIES.
7. GENERAL CONTRACTOR TO INSTALL WIRE HANGERS @ ALL CORNERS OF LIGHT FIXTURES, REGISTERS, & GRILLES.
8. REFER TO INTERIOR & EXTERIOR SECTIONS FOR ADDITIONAL CEILING DETAILS NOT NOTED ON THIS SHEET.
9. ALL RECESSED LIGHTING SHALL BE CENTERED WITHIN THE SOFFIT DIMENSIONS. UON.
10. WHERE ACT IS LOCATED, ALL FIXTURES INCLUDING BUT NOT LIMITED TO MOTION DETECTORS, FIRE ALARM DEVICES, & SPRINKLER HEADS, ARE TO BE LOCATED IN THE CENTER OF THE TILE.
11. WHERE GWB SOFFITS SPAN LONGER THAN 30'-0", CONTROL JOINTS SHOULD BE LOCATED IN GWB SOFFIT EVERY 30'-0". ALIGN WITH CONTROL JOINTS IN GWB WALLS WHERE PRESENT.

KEY NOTES

- 1 ACCESS PANEL - FINISH TO MATCH CEILING
- 3 ROLLER SHADE, N.I.C.
- 4 STAGE CURTAIN
- 5 STL. BEAM, PTD. - REF. STRUCT.
- 20 WALL MOUNTED BASKETBALL GOAL
- 23 CEILING MOUNTED BASKETBALL GOAL

REFLECTED CEILING LEGEND

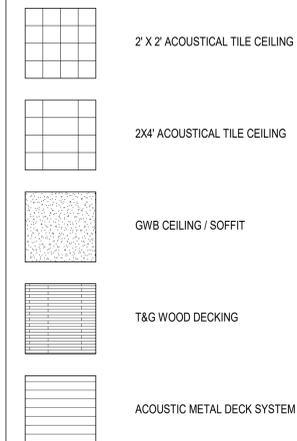

GRAPHIC SCALE(S)



HENDERSON COUNTY SCHOOLS
**EDNEYVILLE
 ELEMENTARY SCHOOL**
 2875 FACE ROAD
 HENDERSONVILLE, NC 28792


CLARK NEXSEN
 301 COLLEGE STREET, SUITE 300
 ASHEVILLE, NORTH CAROLINA 27601
 828.232.0608
 CLARK NEXSEN LICENSE NUMBER: C-1028



SUBMITTAL
 06.04.2018
ISSUED FOR CONSTRUCTION

REVISIONS


B	4/19/2018	ADDENDUM 2
2	7/2/2018	REVISION 2
5	8/29/2018	REVISION 5
10	1/21/2019	REVISION 10
13	5/22/2019	REVISION 13

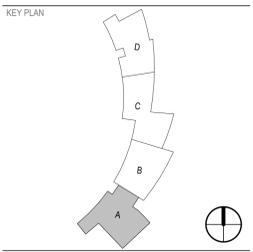

SHEET
**LOWER LEVEL REFLECTED
 CEILING PLAN - AREA A**

A121

CN 5199.D

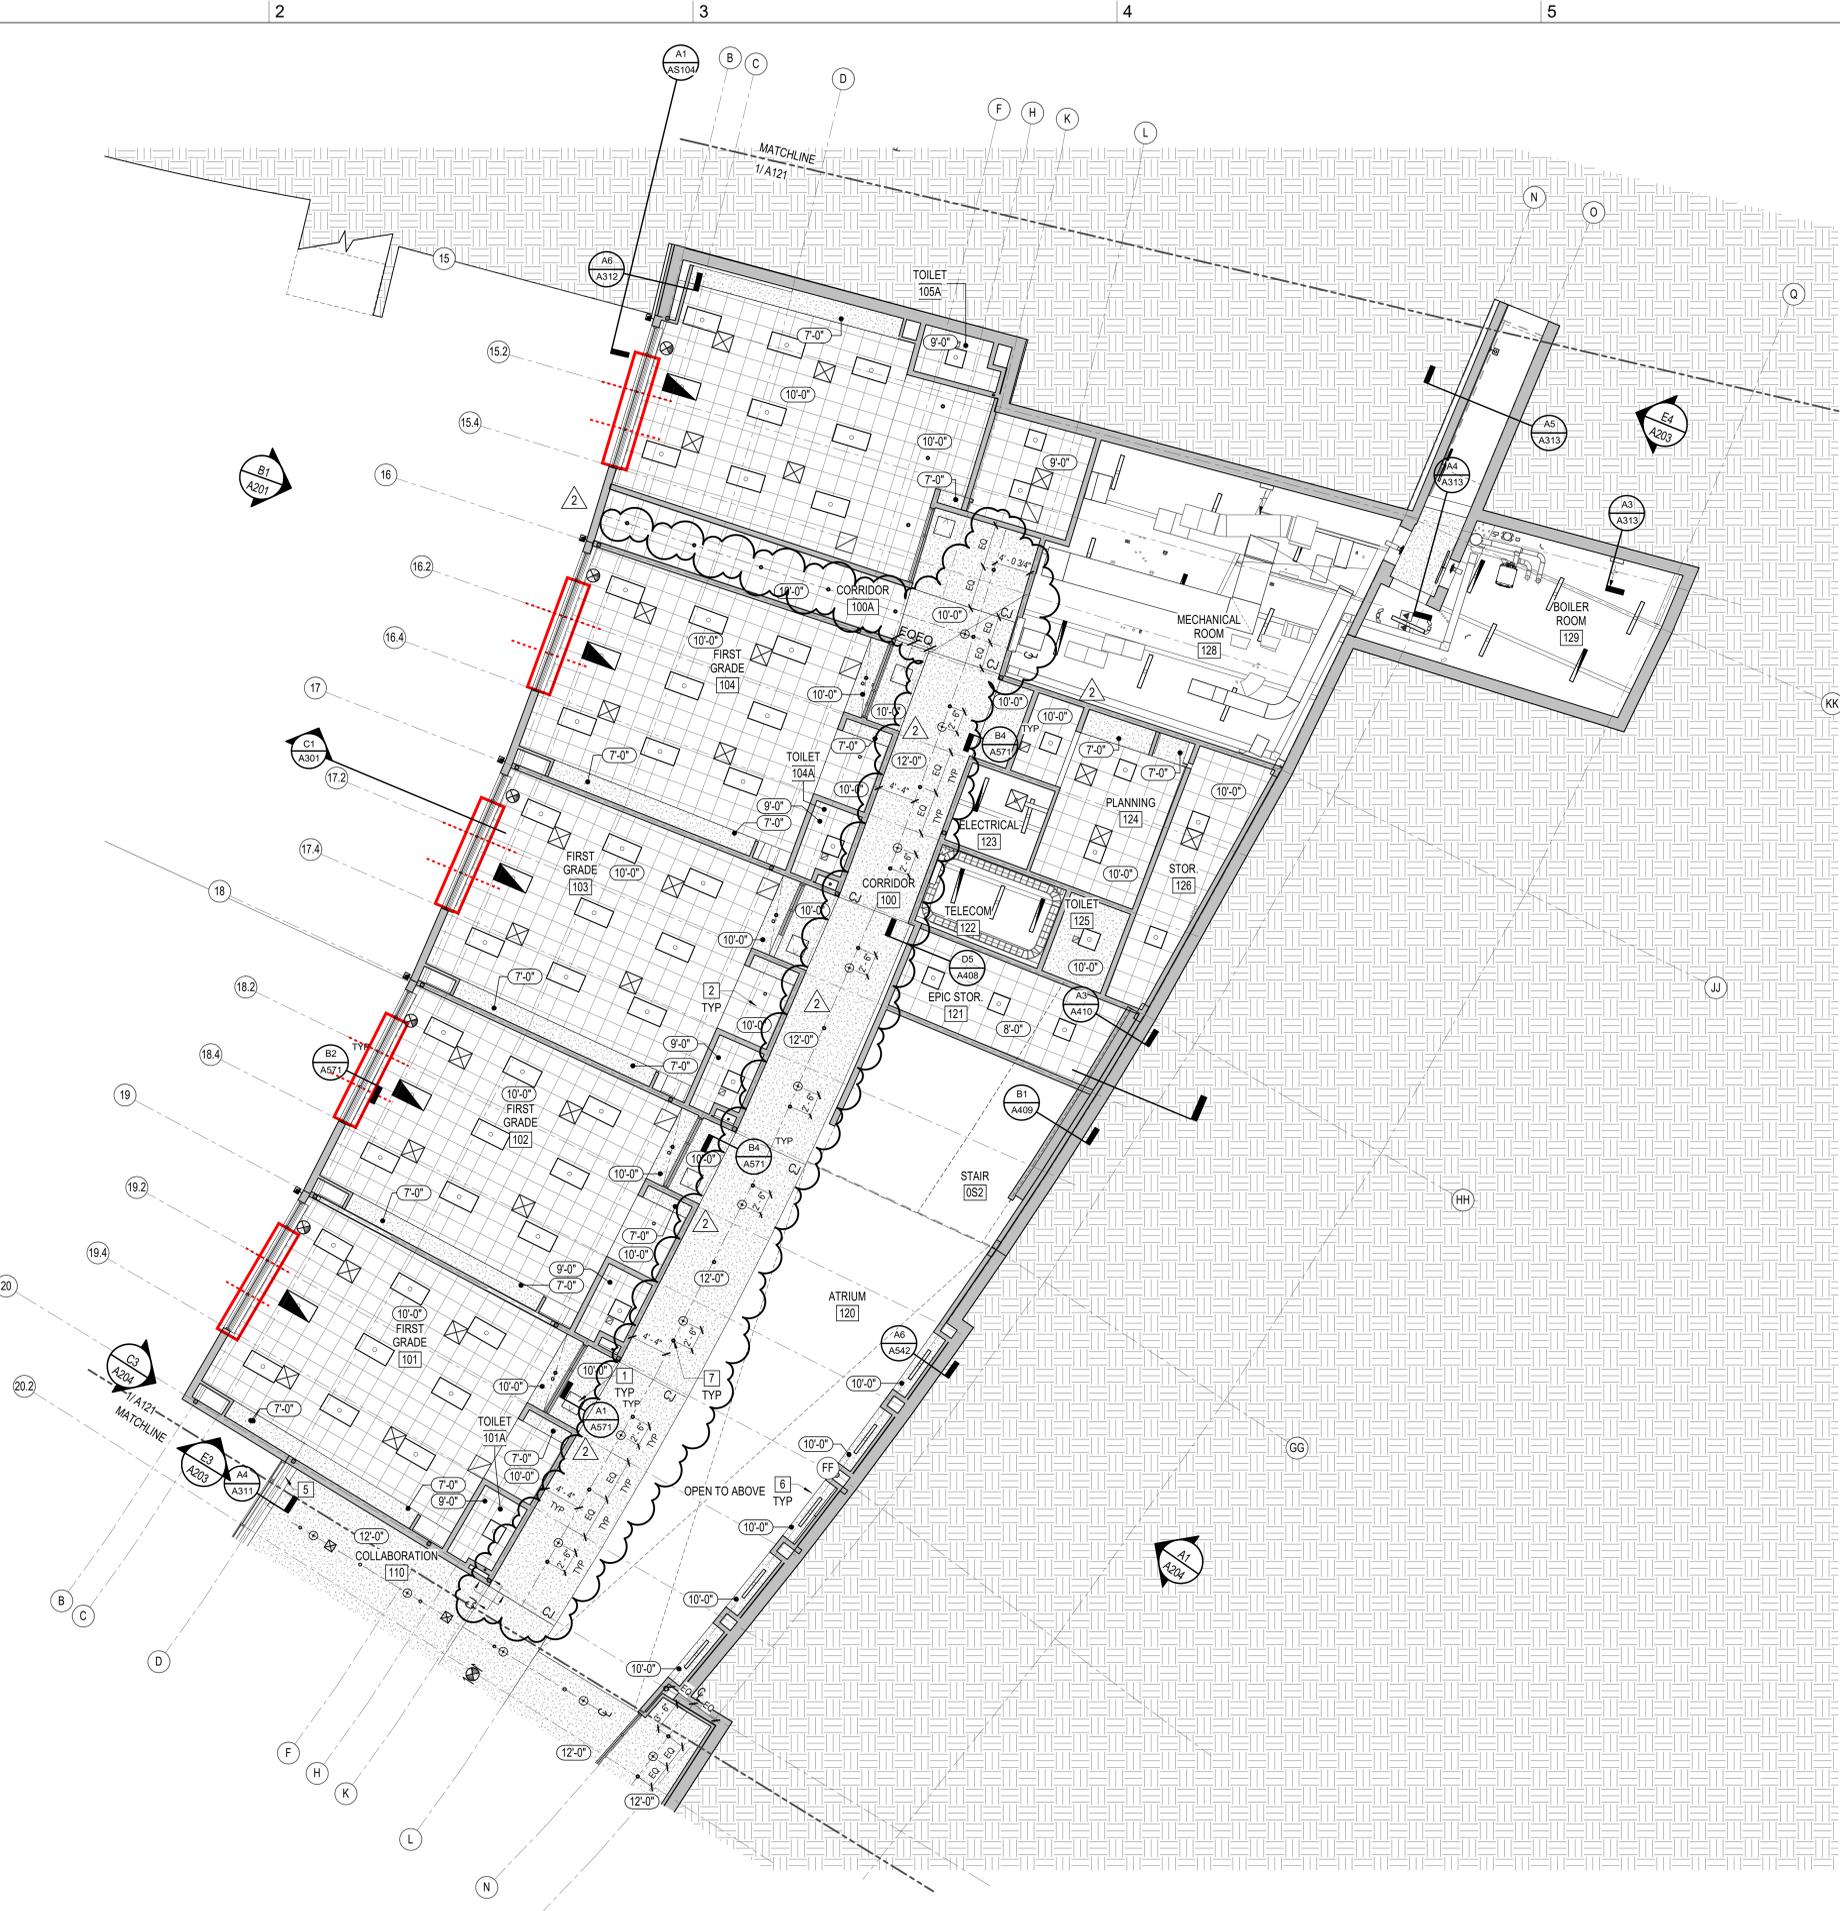


GENERAL NOTES

1. REFER TO SHEET A-001 FOR RCP LEGEND.
2. REFER TO SHEETS A571 - A572 FOR CEILING DETAILS.
3. ALL CEILINGS ARE 10'-0" AFF. UON.
4. HVAC & LIGHTING FIXTURES SHOWN ARE FOR GRAPHICAL PURPOSES ONLY. GC TO REFER TO PME DRAWINGS AND SPRINKLER SHOP DRAWINGS AND SHOULD NOTIFY ARCHITECT IMMEDIATELY OF ANY CONFLICTS OR DISCREPANCIES.
5. GENERAL CONTRACTOR TO COORDINATE ALL SOFFIT/ BULKHEAD FRAMING WITH FINAL LIGHTING FIXTURES & HVAC DIFFUSER LOCATIONS.
6. GENERAL CONTRACTOR TO FIELD VERIFY CEILING HEIGHTS SHOWN ON RCP DRAWINGS PRIOR TO INSTALLATION OF ALL MECHANICAL DUCTWORK, SPRINKLER PIPING, ELECTRICAL EQUIPMENT, CONDUITS, ETC. ARCHITECT TO BE NOTIFIED IMMEDIATELY OF ANY DISCREPANCIES.
7. GENERAL CONTRACTOR TO INSTALL WIRE HANGERS @ ALL CORNERS OF LIGHT FIXTURES, REGISTERS, & GRILLES.
8. REFER TO INTERIOR & EXTERIOR SECTIONS FOR ADDITIONAL CEILING DETAILS NOT NOTED ON THIS SHEET.
9. ALL RECESSED LIGHTING SHALL BE CENTERED WITHIN THE SOFFIT DIMENSIONS. UON.
10. WHERE ACT IS LOCATED, ALL FIXTURES INCLUDING BUT NOT LIMITED TO MOTION DETECTORS, FIRE ALARM DEVICES, & SPRINKLER HEADS, ARE TO BE LOCATED IN THE CENTER OF THE TILE.
11. WHERE GWB SOFFITS SPAN LONGER THAN 30'-0", CONTROL JOINTS SHOULD BE LOCATED IN GWB SOFFIT EVERY 30'-0". ALIGN WITH CONTROL JOINTS IN GWB WALLS WHERE PRESENT.

KEY NOTES

- 1 ACCESS PANEL - FINISH TO MATCH CEILING
- 2 CENTER IN GYP.
- 5 STL. BEAM, PTD. - REF. STRUCT.
- 6 RECESSED SEATING NICHE
- 7 CENTER UNDER SOFFIT AND BETWEEN GRIDLINES

REFLECTED CEILING LEGEND

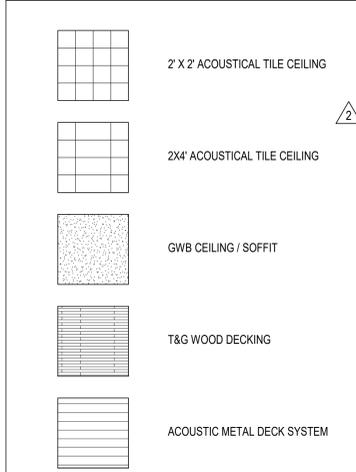

GRAPHIC SCALE(S)



HENDERSON COUNTY SCHOOLS
**EDNEYVILLE
 ELEMENTARY SCHOOL**
 2875 FACE ROAD
 HENDERSONVILLE, NC 28792

DESIGNER
CLARK NEXSEN
 301 COLLEGE STREET, SUITE 300
 ASHEVILLE, NORTH CAROLINA 27601
 828.232.0608
 CLARK NEXSEN LICENSE NUMBER: C-1028


CORPORATE SEAL

 PROFESSIONAL SEAL


SUBMITTAL
 06.04.2018
ISSUED FOR CONSTRUCTION

REVISIONS

B	4/19/2018	ADDENDUM 2
2	7/2/2018	REVISION 2
13	5/22/2019	REVISION 13

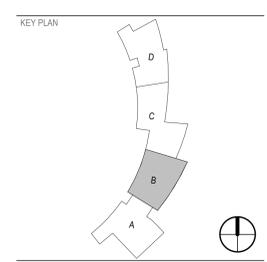

SHEET
**LOWER LEVEL REFLECTED
 CEILING PLAN - AREA B**

A122

CN 5199.D

1
A122
 1/8" = 1'-0"
 REF B1 / A200

5/23/2019 11:50:22 AM
 C:\rent\Projects\1980_Edneyville Elem A17_murdaugh.rvt




GENERAL NOTES

- REFER TO SHEET A-001 FOR RCP LEGEND.
- REFER TO SHEETS A571 - A572 FOR CEILING DETAILS.
- ALL CEILINGS ARE 10'-0" AFF. UON.
- HVAC & LIGHTING FIXTURES SHOWN ARE FOR GRAPHICAL PURPOSES ONLY. GC TO REFER TO PME DRAWINGS AND SPRINKLER PIPING SHOP DRAWINGS AND SHOULD NOTIFY ARCHITECT IMMEDIATELY OF ANY CONFLICTS OR DISCREPANCIES.
- GENERAL CONTRACTOR TO COORDINATE ALL SOFFIT/ BULKHEAD FRAMING WITH FINAL LIGHTING FIXTURES & HVAC DIFFUSER LOCATIONS.
- GENERAL CONTRACTOR TO FIELD VERIFY CEILING HEIGHTS SHOWN ON RCP DRAWINGS PRIOR TO INSTALLATION OF ALL MECHANICAL DUCTWORK, SPRINKLER PIPING, ELECTRICAL EQUIPMENT, CONDUITS, ETC. ARCHITECT TO BE NOTIFIED IMMEDIATELY OF ANY DISCREPANCIES.
- GENERAL CONTRACTOR TO INSTALL WIRE HANGERS @ ALL CORNERS OF LIGHT FIXTURES, REGISTERS, & GRILLES.
- REFER TO INTERIOR & EXTERIOR SECTIONS FOR ADDITIONAL CEILING DETAILS NOT NOTED ON THIS SHEET.
- ALL RECESSED LIGHTING SHALL BE CENTERED WITHIN THE SOFFIT DIMENSIONS, UON.
- WHERE ACT IS LOCATED, ALL FIXTURES INCLUDING BUT NOT LIMITED TO MOTION DETECTORS, FIRE ALARM DEVICES, & SPRINKLER HEADS, ARE TO BE LOCATED IN THE CENTER OF THE TILE.
- WHERE GWB SOFFITS SPAN LONGER THAN 30'-0", CONTROL JOINTS SHOULD BE LOCATED IN GWB SOFFIT EVERY 30'-0". ALIGN WITH CONTROL JOINTS IN GWB WALLS WHERE PRESENT.

KEY NOTES

- ACCESS PANEL - FINISH TO MATCH CEILING
- STL. BEAM, PTD. - REF. STRUCT.
- FACTORY FINISHED ALUM. RWL
- FACTORY FINISHED ALUM. GUTTER
- ALUM. CANOPY
- LINEAR LIGHT FIXTURE ATTACHED TO SIDE OF INVERTED TRUSS - REF. ELEC.
- FABRIC DUCT - REF. MECH.
- PENDANT LIGHT FIXTURE - REF. ELEC.
- WALL MOUNTED LIGHT FIXTURE - REF. ELEC.
- FIBER REINFORCED CONCRETE SOFFIT PANELS
- CEILING MOUNTED ACOUSTIC PANEL

REFLECTED CEILING LEGEND

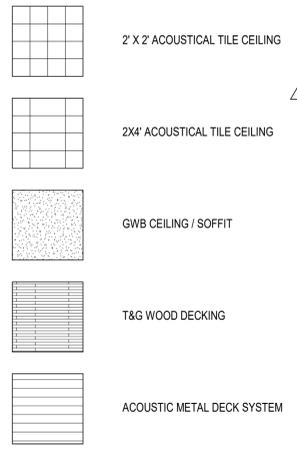

GRAPHIC SCALE(S)



HENDERSON COUNTY SCHOOLS
**EDNEYVILLE
 ELEMENTARY SCHOOL**
 2875 FACE ROAD
 HENDERSONVILLE, NC 28792


DESIGNER
CLARK NEXSEN
 301 COLLEGE STREET, SUITE 300
 ASHEVILLE, NORTH CAROLINA 27601
 828-232-0608
 CLARK NEXSEN LICENSE NUMBER: C-1028



SUBMITTAL
 06.04.2018
ISSUED FOR CONSTRUCTION

REVISIONS

B	4/19/2018	ADDENDUM 2
2	7/2/2018	REVISION 2
3	7/20/2018	REVISION 3
7	10/1/2018	REVISION 7
10	1/21/2019	REVISION 10
12	3/27/2019	REVISION 12
13	5/22/2019	REVISION 13

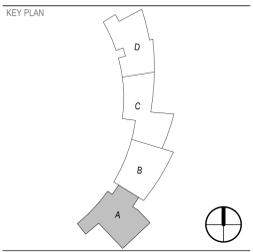

SHEET
**MAIN LEVEL REFLECTED
 CEILING PLAN - AREA A**

A123

CN 5199.D

5/24/2019 2:33:44 PM
 C:\Users\adam\Documents\Local Revit Projects\19602_Edneyville Elem A17_dbramcvt

A1
A123 1/8" = 1'-0"
 REF: A2 / A200




GENERAL NOTES

1. REFER TO SHEET A-001 FOR RCP LEGEND.
2. REFER TO SHEETS A571 - A572 FOR CEILING DETAILS.
3. ALL CEILINGS ARE 10'-0" AFF. UON.
4. HVAC & LIGHTING FIXTURES SHOWN ARE FOR GRAPHICAL PURPOSES ONLY. GC TO REFER TO PME DRAWINGS AND SPRINKLER PIPING SHOP DRAWINGS AND SHOULD NOTIFY ARCHITECT IMMEDIATELY OF ANY CONFLICTS OR DISCREPANCIES.
5. GENERAL CONTRACTOR TO COORDINATE ALL SOFFIT/BULKHEAD FRAMING WITH FINAL LIGHTING FIXTURES & HVAC DIFFUSER LOCATIONS.
6. GENERAL CONTRACTOR TO FIELD VERIFY CEILING HEIGHTS SHOWN ON RCP DRAWINGS PRIOR TO INSTALLATION OF ALL MECHANICAL DUCTWORK, SPRINKLER PIPING, ELECTRICAL EQUIPMENT, CONDUITS, ETC. ARCHITECT TO BE NOTIFIED IMMEDIATELY OF ANY DISCREPANCIES.
7. GENERAL CONTRACTOR TO INSTALL WIRE HANGERS @ ALL CORNERS OF LIGHT FIXTURES, REGISTERS, & GRILLES.
8. REFER TO INTERIOR & EXTERIOR SECTIONS FOR ADDITIONAL CEILING DETAILS NOT NOTED ON THIS SHEET.
9. ALL RECESSED LIGHTING SHALL BE CENTERED WITHIN THE SOFFIT DIMENSIONS, UON.
10. WHERE ACT IS LOCATED, ALL FIXTURES INCLUDING BUT NOT LIMITED TO MOTION DETECTORS, FIRE ALARM DEVICES, & SPRINKLER HEADS, ARE TO BE LOCATED IN THE CENTER OF THE TILE.
11. WHERE GWB SOFFITS SPAN LONGER THAN 30'-0", CONTROL JOINTS SHOULD BE LOCATED IN GWB SOFFIT EVERY 30'-0". ALIGN WITH CONTROL JOINTS IN GWB WALLS WHERE PRESENT.

KEY NOTES

- 3 ROLLER SHADE, N.I.C.
- 5 STL. BEAM, PTD. - REF. STRUCT.
- 12 GLULAM BEAM OR TRUSS - REFER TO STRUCTURAL
- 16 FACTORY FINISHED ALUM. RWL
- 24 LINEAR LIGHT FIXTURE ATTACHED TO SIDE OF INVERTED TRUSS - REF. ELEC.
- 29 ACCESS PANEL - FINISH TO MATCH CEILING. ALIGN W/ E.O. DELITE BELOW, TYP. ALL 3RD GRADE.
- 30 OVERFLOW DRAIN WITH SOFFIT GRILLE. SEE DETAIL A5/A526
- 31 ROOF DRAIN LEADER
- 35 DIRECT APPLIED FINISH SYSTEM
- 36 CONTROL JOINT

REFLECTED CEILING LEGEND

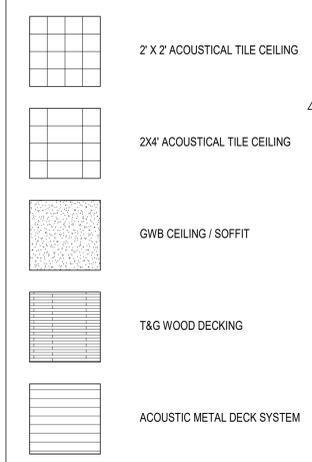

GRAPHIC SCALE(S)



HENDERSON COUNTY SCHOOLS
**EDNEYVILLE
 ELEMENTARY SCHOOL**
 2875 FACE ROAD
 HENDERSONVILLE, NC 28792


DESIGNER
CLARK NEXSEN
 301 COLLEGE STREET, SUITE 300
 ASHEVILLE, NORTH CAROLINA 27601
 828.232.0608
 CLARK NEXSEN LICENSE NUMBER: C-1028



SUBMITTAL
 06.04.2018
ISSUED FOR CONSTRUCTION

REVISIONS

B	4/19/2018	ADDENDUM 2
3	7/20/2018	REVISION 3
10	1/21/2019	REVISION 10
11	3/07/2019	REVISION 11
13	5/22/2019	REVISION 13

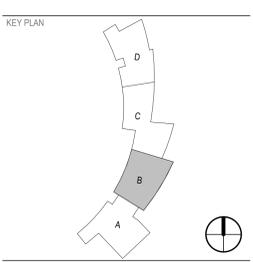

SHEET
**MAIN LEVEL REFLECTED
 CEILING PLAN - AREA B**

A124

CN 5199.D

5/23/2019 11:51:38 AM
 C:\Users\Project\1980_Edneyville Elem A124_murdaugh.rvt

A1
 A124
MAIN LEVEL RCP - AREA B
 1/8" = 1'-0" REF A2 / A200

DESIGNER

CLARK NEXSEN

301 COLLEGE STREET, SUITE 300
ASHEVILLE, NORTH CAROLINA 27601
828-232-0608

CLARK NEXSEN LICENSE NUMBER: C-1028

CORPORATE SEAL



PROFESSIONAL SEAL



SUBMITTAL


06.04.2018

ISSUED FOR CONSTRUCTION

REVISIONS

2	7/2/2018	REVISION 2
3	7/20/2018	REVISION 3
12	3/27/2019	REVISION 12
13	5/22/2019	REVISION 13

 KEY PLAN



SHEET

**MAIN LEVEL REFLECTED
CEILING PLAN - AREA C**

A125

CN 5199.D

GENERAL NOTES

- REFER TO SHEET A-001 FOR RCP LEGEND.
- REFER TO SHEETS A571 - A572 FOR CEILING DETAILS.
- ALL CEILINGS ARE 10'-0" AFF. UON.
- HVAC & LIGHTING FIXTURES SHOWN ARE FOR GRAPHICAL PURPOSES ONLY. GC TO REFER TO PME DRAWINGS AND SPRINKLER PIPING SHOP DRAWINGS AND SHOULD NOTIFY ARCHITECT IMMEDIATELY OF ANY CONFLICTS OR DISCREPANCIES.
- GENERAL CONTRACTOR TO COORDINATE ALL SOFFIT/ BULKHEAD FRAMING WITH FINAL LIGHTING FIXTURES & HVAC DIFFUSER LOCATIONS.
- GENERAL CONTRACTOR TO FIELD VERIFY CEILING HEIGHTS SHOWN ON RCP DRAWINGS PRIOR TO INSTALLATION OF ALL MECHANICAL DUCTWORK, SPRINKLER PIPING, ELECTRICAL EQUIPMENT, CONDUITS, ETC. ARCHITECT TO BE NOTIFIED IMMEDIATELY OF ANY DISCREPANCIES.
- GENERAL CONTRACTOR TO INSTALL WIRE HANGERS @ ALL CORNERS OF LIGHT FIXTURES, REGISTERS, & GRILLES.
- REFER TO INTERIOR & EXTERIOR SECTIONS FOR ADDITIONAL CEILING DETAILS NOT NOTED ON THIS SHEET.
- ALL RECESSED LIGHTING SHALL BE CENTERED WITHIN THE SOFFIT DIMENSIONS, UON.
- WHERE ACT IS LOCATED, ALL FIXTURES INCLUDING BUT NOT LIMITED TO MOTION DETECTORS, FIRE ALARM DEVICES, & SPRINKLER HEADS, ARE TO BE LOCATED IN THE CENTER OF THE TILE.
- WHERE GWB SOFFITS SPAN LONGER THAN 30'-0", CONTROL JOINTS SHOULD BE LOCATED IN GWB SOFFIT EVERY 30'-0". ALIGN WITH CONTROL JOINTS IN GWB WALLS WHERE PRESENT.



KEY NOTES

- ROLLER SHADE, N.I.C.
- STL. BEAM, PTD. - REF. STRUCT.
- GLULAM BEAM OR TRUSS - REFER TO STRUCTURAL
- FACTORY FINISHED ALUM. RWL
- FACTORY FINISHED ALUM. GUTTER
- FABRIC DUCT - REF. MECH.
- ROOF DRAIN LEADER
- EXPANSION JOINT
- DIRECT APPLIED FINISH SYSTEM
- CONTROL JOINT
- PIPE OR CONDUIT CORED THROUGH CENTER OF GLULAM BEAMS AT 1'-0" CENTERS, TYP. REFER TO PLUMBING, MECHANICAL, AND ELECTRICAL DRAWINGS

REFLECTED CEILING LEGEND

	2' X 2' ACOUSTICAL TILE CEILING
	2X4' ACOUSTICAL TILE CEILING
	GWB CEILING / SOFFIT
	T&G WOOD DECKING
	ACOUSTIC METAL DECK SYSTEM

 GRAPHIC SCALE(S)

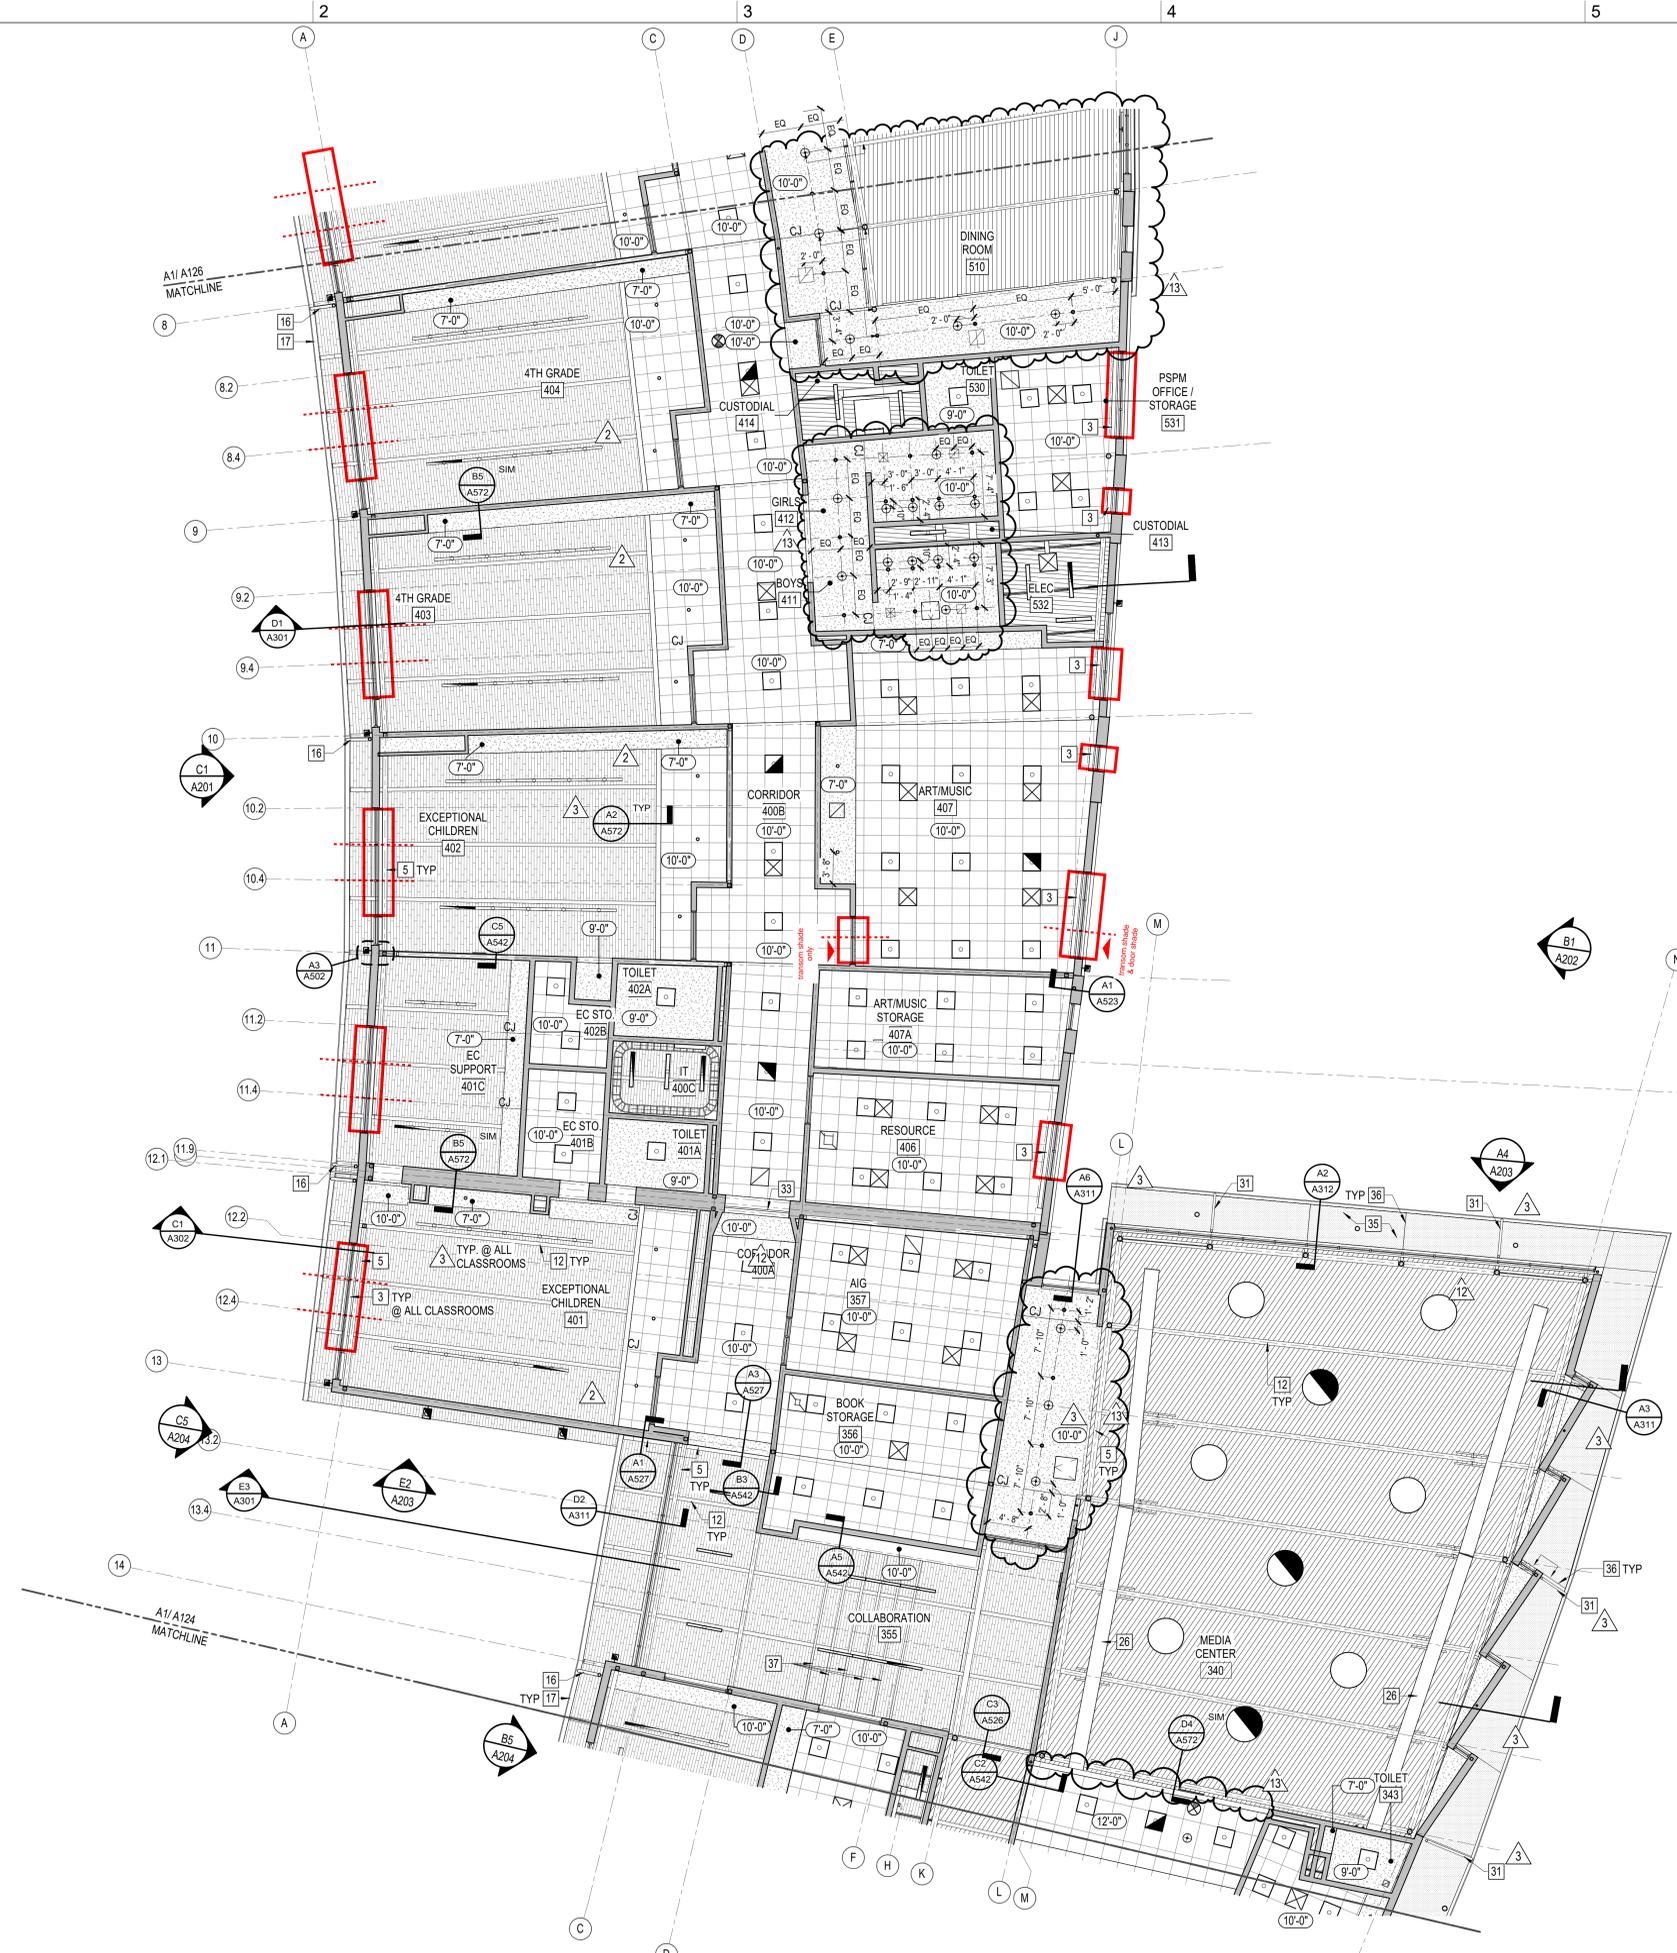

MAIN LEVEL RCP - AREA C
1/8" = 1'-0" REF A2 / A200

5/23/2019 11:51:50 AM
C:\rent\Projects\190_Edneysville Elem A125_murdaugh.rvt




GENERAL NOTES

- REFER TO SHEET A-001 FOR RCP LEGEND.
- REFER TO SHEETS A571 - A572 FOR CEILING DETAILS.
- ALL CEILINGS ARE 10'-0" AFF. UON.
- HVAC & LIGHTING FIXTURES SHOWN ARE FOR GRAPHICAL PURPOSES ONLY. GC TO REFER TO PME DRAWINGS AND SPRINKLER PIPING SHOP DRAWINGS AND SHOULD NOTIFY ARCHITECT IMMEDIATELY OF ANY CONFLICTS OR DISCREPANCIES.
- GENERAL CONTRACTOR TO COORDINATE ALL SOFFIT/BULKHEAD FRAMING WITH FINAL LIGHTING FIXTURES & HVAC DIFFUSER LOCATIONS.
- GENERAL CONTRACTOR TO FIELD VERIFY CEILING HEIGHTS SHOWN ON RCP DRAWINGS PRIOR TO INSTALLATION OF ALL MECHANICAL DUCTWORK, SPRINKLER PIPING, ELECTRICAL EQUIPMENT, CONDUITS, ETC. ARCHITECT TO BE NOTIFIED IMMEDIATELY OF ANY DISCREPANCIES.
- GENERAL CONTRACTOR TO INSTALL WIRE HANGERS @ ALL CORNERS OF LIGHT FIXTURES, REGISTERS, & GRILLES.
- REFER TO INTERIOR & EXTERIOR SECTIONS FOR ADDITIONAL CEILING DETAILS NOT NOTED ON THIS SHEET.
- ALL RECESSED LIGHTING SHALL BE CENTERED WITHIN THE SOFFIT DIMENSIONS, UON.
- WHERE ACT IS LOCATED, ALL FIXTURES INCLUDING BUT NOT LIMITED TO MOTION DETECTORS, FIRE ALARM DEVICES, & SPRINKLER HEADS, ARE TO BE LOCATED IN THE CENTER OF THE TILE.
- WHERE GWB SOFFITS SPAN LONGER THAN 30'-0", CONTROL JOINTS SHOULD BE LOCATED IN GWB SOFFIT EVERY 30'-0". ALIGN WITH CONTROL JOINTS IN GWB WALLS WHERE PRESENT.

KEY NOTES

- DUCT - REFER TO MECHANICAL
- KITCHEN HOOD EQUIPMENT - REFER TO MECHANICAL
- GLULAM BEAM OR TRUSS - REFER TO STRUCTURAL
- SPECIFIED FREEZER/COOLER UNIT
- FACTORY FINISHED ALUM. RWL
- FACTORY FINISHED ALUM. GUTTER
- LINEAR LIGHT FIXTURE ATTACHED TO SIDE OF INVERTED TRUSS - REF. ELEC.

REFLECTED CEILING LEGEND

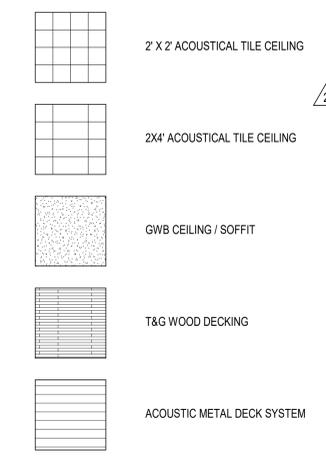

GRAPHIC SCALE(S)



HENDERSON COUNTY SCHOOLS
EDNEYVILLE ELEMENTARY SCHOOL
 2875 FACE ROAD
 HENDERSONVILLE, NC 28792


DESIGNER
CLARK NEXSEN
 301 COLLEGE STREET, SUITE 300
 ASHEVILLE, NORTH CAROLINA 27601
 828.232.0608
 CLARK NEXSEN LICENSE NUMBER: C-1028



SUBMITTAL
 06.04.2018
ISSUED FOR CONSTRUCTION

REVISIONS

B	4/19/2018	ADDENDUM 2
2	7/2/2018	REVISION 2
3	7/20/2018	REVISION 3
12	3/27/2019	REVISION 12
13	5/22/2019	REVISION 13

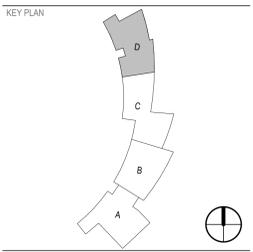

SHEET
MAIN LEVEL REFLECTED CEILING PLAN - AREA D

A126